



**City of Tampa**

*Jane Castor, Mayor*

**Contract Administration**

**Michael W. Chucran, Director**

306 East Jackson Street, 4N

Tampa, FL 33602

Office (813) 274-8116

Fax: (813) 274-7368

**ADDENDUM 3**

**Via E-Mail**

**DATE: January 30, 2020**

Contract 19-C-00051; Howard F. Curren AWTP Methanol Storage Tank Replacement


Bidders on the above referenced project are hereby notified that the following addendum is made to the Contract Documents. BIDS TO BE SUBMITTED SHALL CONFORM TO THIS NOTICE.

Item 1: Replace Plan Sheet M-01 MECHANICAL PLAN –METHANOL STORAGE TANKS with the attached Plan Sheet M-01.

All other provisions of the Contract Documents and Specifications not in conflict with this Addendum shall remain in full force and effect. Questions are to be e-mailed to Contract Administration@tampagov.net.

*Jim Greiner*


Jim Greiner, P.E., Contract Management Supervisor

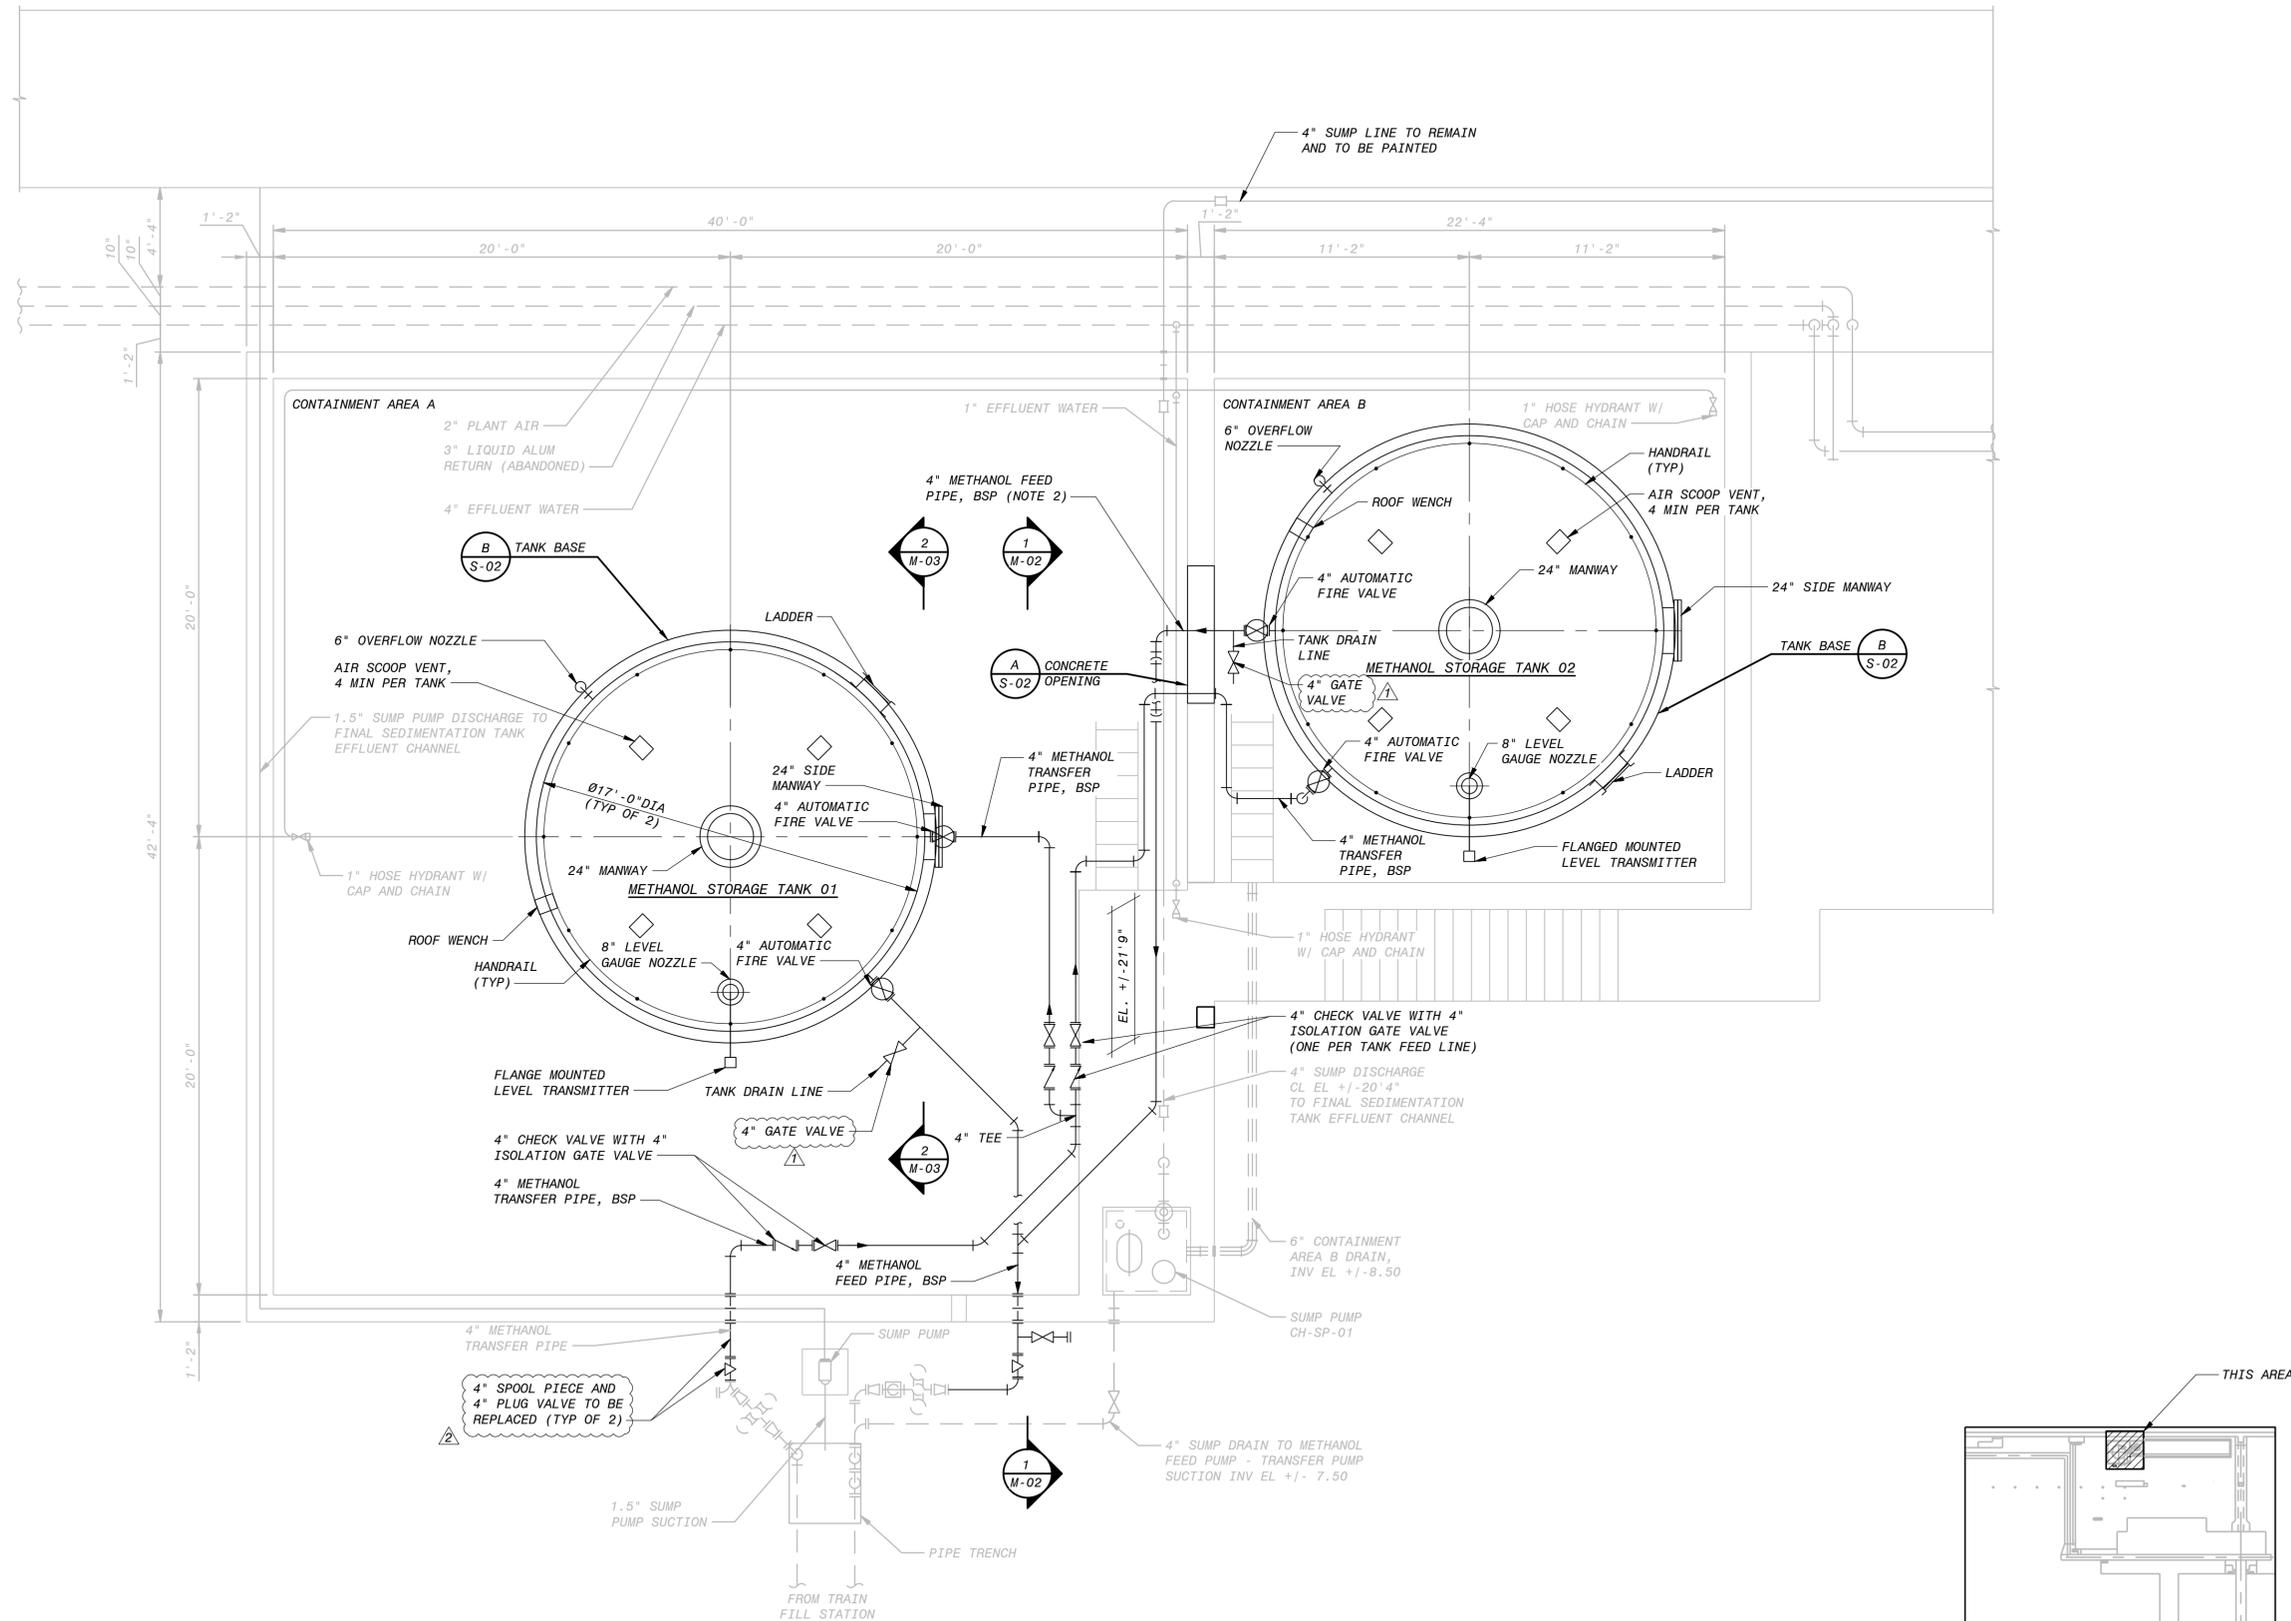


**NOTES:**

1. NEW METHANOL TANKS SHALL BE CONSTRUCTED OF 316L STAINLESS STEEL.
2. 4" METHANOL FEED PIPE SHALL BE ROUTED THROUGH THE OPENING CREATED TO COMBINE CONTAINMENT AREAS A AND B. REFER TO DEMOLITION AND STRUCTURAL DRAWINGS FOR DETAILS.
3. METHANOL TANKS TO BE INSTALLED IN A MANNER THAT WILL NOT INTERRUPT METHANOL SERVICE TO THE FACILITY.
4. 4" METHANOL TRANSFER PIPE TO BE INSTALLED 6" ABOVE TANK BOTTOM AT POINT OF ENTRY INTO THE TANK.
5. METHANOL PIPING ROUTING LOCATIONS SHOWN ARE APPROXIMATE. CONTRACTOR TO FIELD VERIFY ALL CHEMICAL TRANSFER AND FEED PIPING LOCATIONS. REFERENCE P&IDS (SHEET I-2) FOR METHANOL PIPING REQUIREMENTS..
6. TANK AND ANCILLARY EQUIPMENT SHOWING GENERAL LOCATION AND OVERALL TANK SIZE.

**SITE PLAN**  
1" = 4'-0"

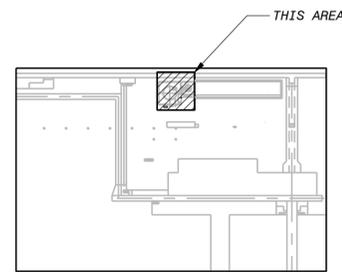

**KEY PLAN**

 

JAN 2020	ADDENDUM REVISION	1, 2	AD	EB	DH
NOV 2019	100% SUBMISSION	E	AD	BV	DH
AUG 2019	90% SUBMITTAL	D	AD	EE	VE
JUNE 2019	60% SUBMISSION	C	AD	EE	DH
DATE	REVISIONS AND RECORD OF ISSUE	NO.	BY	CHK	APP
	50-3090 - Mechanical Drawings				
	M-01.dwg				
	SAVED: BOM14813, 1/29/2020 1:13:15 PM				
	PLOTTED: BOM14813, 1/29/2020 1:16:24 PM				
	USER: BOM14813				
	DWG VER: 1005				

**BLACK & VEATCH**  
Building a world of difference

Black & Veatch Corporation  
3405 W. Dr. M. L. King Jr. Blvd, Suite 125  
Tampa, Florida  
Certificate No. 8132

**CITY OF TAMPA**  
**HOWARD F. CURREN AWWP**  
**METHANOL STORAGE TANK REPLACEMENT**

MECHANICAL  
PLAN - METHANOL STORAGE TANKS

DESIGNED: NE
DETAILED: HT
CHECKED: EB
APPROVED: DH
DATE: JANUARY 2020

0 1/2 1  
IF THIS BAR DOES NOT MEASURE 1" THEN DRAWING IS NOT TO FULL SCALE

PROJECT NO.  
**401265**  
**M-01**  
SHEET  
7 OF 22